



200 AMP		CONNECTED LOAD 38.36 K.W. 159.83 AMP							
U.S.	ITEMS	K.W.	B.K.R.	C.C.T.	B.K.R.	K.W.	ITEMS	U.S.	
10	RANGE	7.20	2/40	1	2	2/50	8.00	AIR CONDITIONER	6
-	-	-	-	3	4	-	-	-	-
10	DRYER	4.00	2/30	5	6	1/15	0.40	UP HALL BATH LIGHTS - RADON	14
-	-	-	-	7	8	1/15	0.10	SECURITY OUTLET	12
12	REFRIGERATOR	1.00	1/20	9	10	1/20	0.80	KITCHEN GFI	12
12	KITCHEN GFI	0.80	1/20	11	12	1/20	0.30	DINING - ARC FAULT	12
12	WASHER	1.00	1/20	13	14	1/15	0.80	FAMILY ROOM - ARC FAULT	14
12	DINETTE - ARC FAULT	0.80	1/20	15	16	1/15	0.40	FIRST FLOOR LIGHTS - ARC FAULT	14
12	BATH GFI	0.80	1/20	17	18	1/15	1.00	DISHWASHER	14
12	BATH GFI	0.80	1/20	19	20	1/15	0.30	DISPOSAL	14
14	FURNACE	0.80	1/15	21	22	1/15	0.30	SUMP OUTLET	14
14	BEDROOM - ARC FAULT	1.00	1/15	23	24	1/15	0.30	LOWER LEVEL - ARC FAULT	14
14	BEDROOM - ARC FAULT	1.00	1/15	25	26	-	-	SPARE	-
14	SMOKE DETECTOR - ARC FAULT	0.30	1/15	27	28	1/15	0.80	HALL LIGHTING	14
12	MICROWAVE	1.80	1/20	29	30	1/15	0.30	STAIR LIGHTING - ARC FAULT	14
14	BASEMENT LIGHTING	0.84	1/15	31	32	1/15	0.40	UPSTAIRS LIGHTING - ARC FAULT	14
-	SPARE	-	-	33	34	1/15	0.70	GARAGE GFI	14
-	SPARE	-	-	35	36	1/15	0.30	MASTER BEDROOM - ARC FAULT	14
-	SPARE	-	-	37	38	-	-	SPARE	-
-	SPARE	-	-	39	40	-	-	SPARE	-

ELECTRICAL LEGEND		
ELECTRICAL	COUNT	SYMBOL
Continuous Run Fan	1	⊗
Elec Panel	1	□
Security Outlet	1	⊕
light	7	⊙
outlet	1	⊕
outlet gfi	1	⊕
smoke & carbon detector	1	⊗
switch	2	⊕
switch 3 way	1	⊕

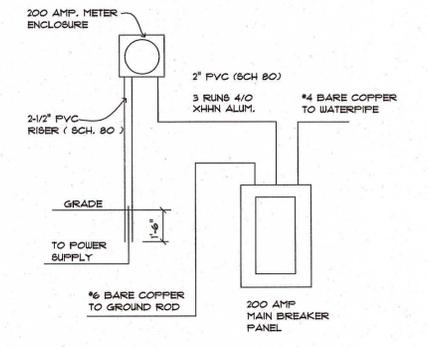

ELECTRICAL SERVICE DIAGRAM
NO SCALE

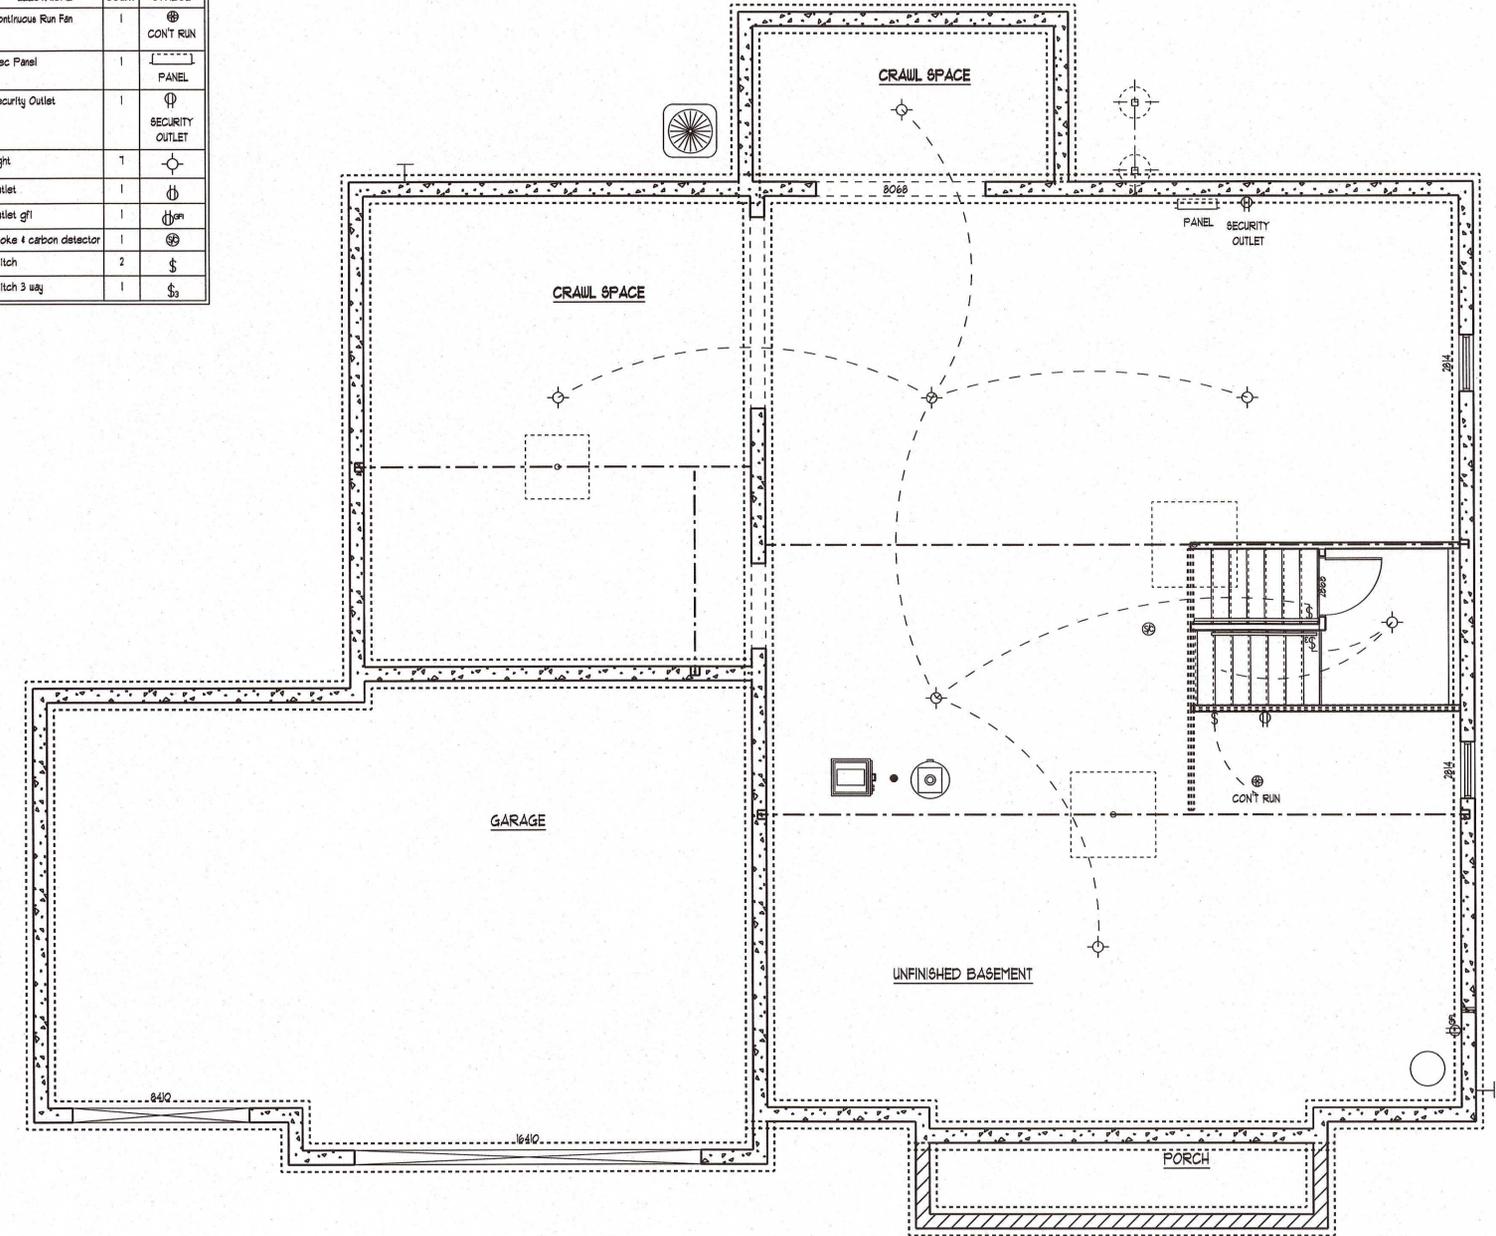

FOUNDATION PLAN
ELECTRICAL

APPROVED
CUR 2/7/19

PAGE: C1

MODEL: ANDOVER FARMHOUSE

LOT:

SUBDIVISION:

SCALE: AS NOTED ON DRAWING

VERSION: 2018.V2

DATE: 2/7/2019


Virginia Homes
The Pigeon Building Group, Ltd.
10104 Brewster Lane Suite 100
Powell, Ohio 43065
Phone: (614) 764-1953 Fax: (614) 764-1955
www.virginia-homes.com

VIRGINIA HOMES

ANDOVER - FARMHOUSE
BASE PLAN


ELECTRICAL	COUNT	SYMBOL
can light 6inch UP	3	⊙ _{up}
Fan	2	⊕
Fan light	2	⊕ _o
light	21	⊙
outlet	28	⊕
outlet 220v	1	⊕ ₂₂₀
outlet gf1	5	⊕ _{gf1}
smoke & carbon detector	1	⊕ _{scd}
smoke detector 2	6	⊕ _{sd}
switch	22	⊕ _s
switch 3 way	3	⊕ _{3s}

RADON OUTLET TO BE LOCATED IN PROXIMITY TO RADON PIPE IN ATTIC

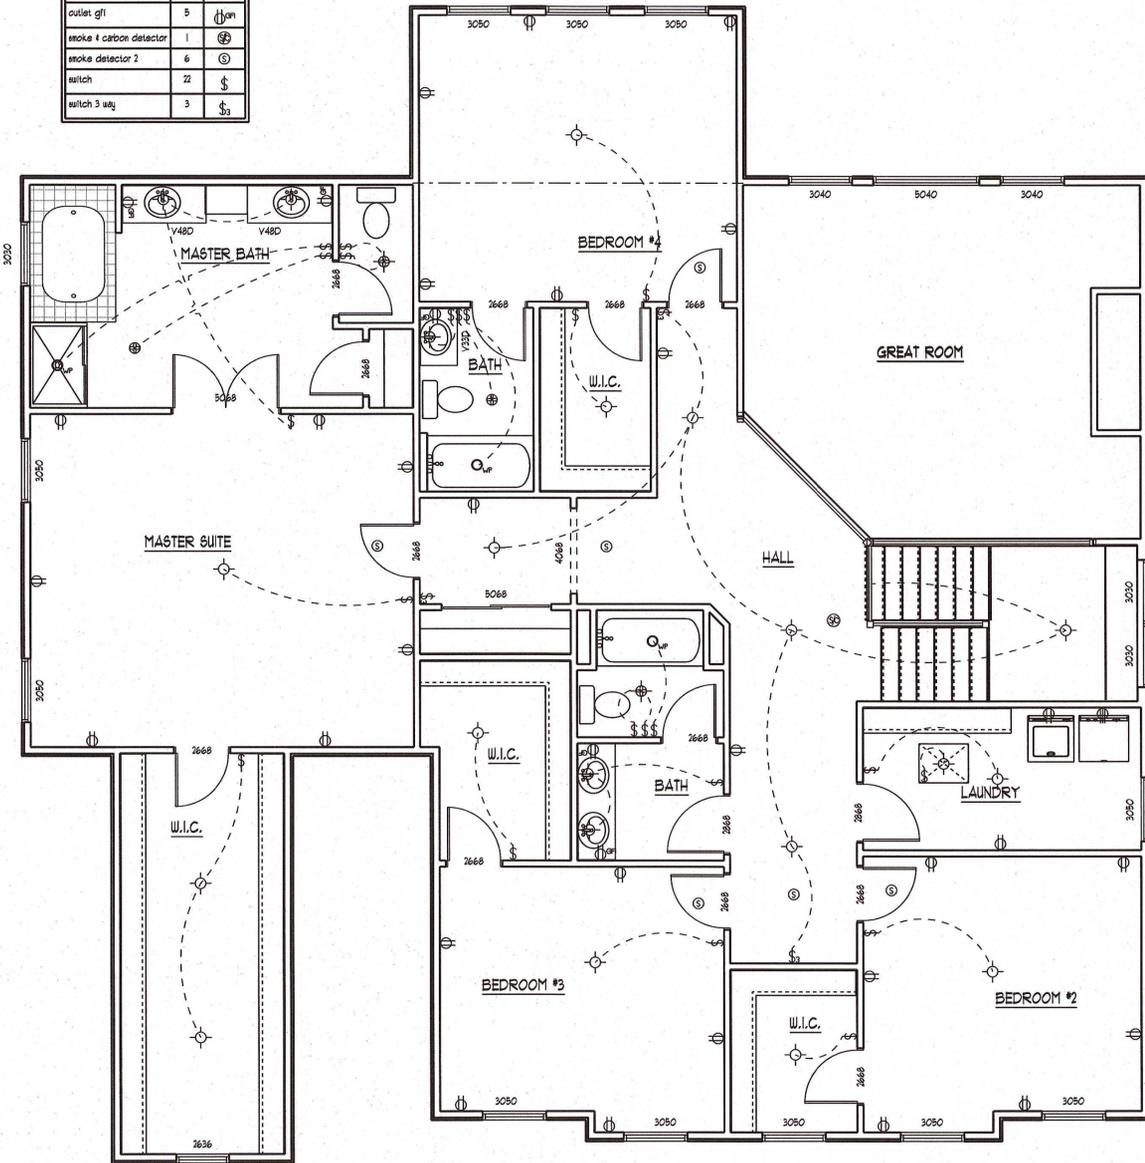

SECOND FLOOR PLAN
ELECTRICAL

ELECTRICAL	COUNT	SYMBOL
can light 6inch	13	⊙
hanging globe light	2	⊙ _o
Air Conditioning Outlet	1	A/C
Fan	1	⊕
light	23	⊙
outlet	46	⊕
outlet 220v	2	⊕ ₂₂₀
outlet gf1	5	⊕ _{gf1}
outlet up	4	⊕ _{up}
smoke & carbon detector	1	⊕ _{scd}
switch	13	⊕ _s
switch 3 way	3	⊕ _{3s}

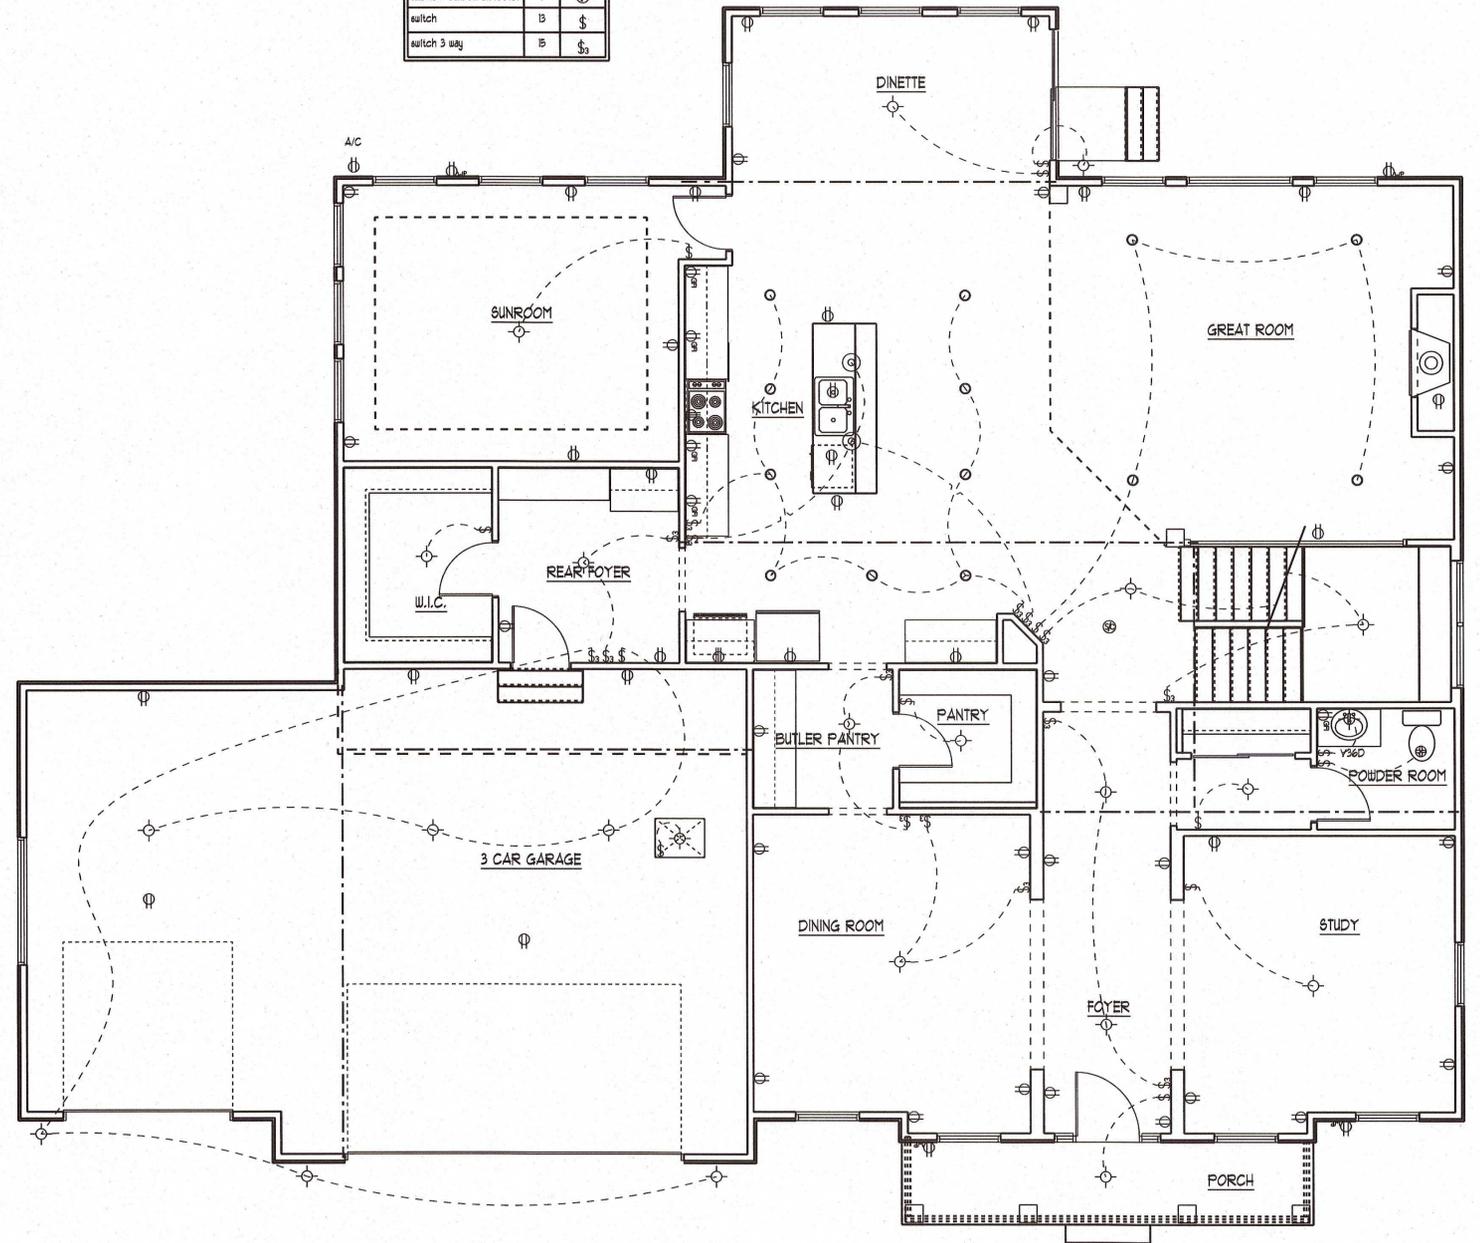

FIRST FLOOR PLAN
ELECTRICAL

APPROVED
CUM 2/7/19